top one inch to be trimmed

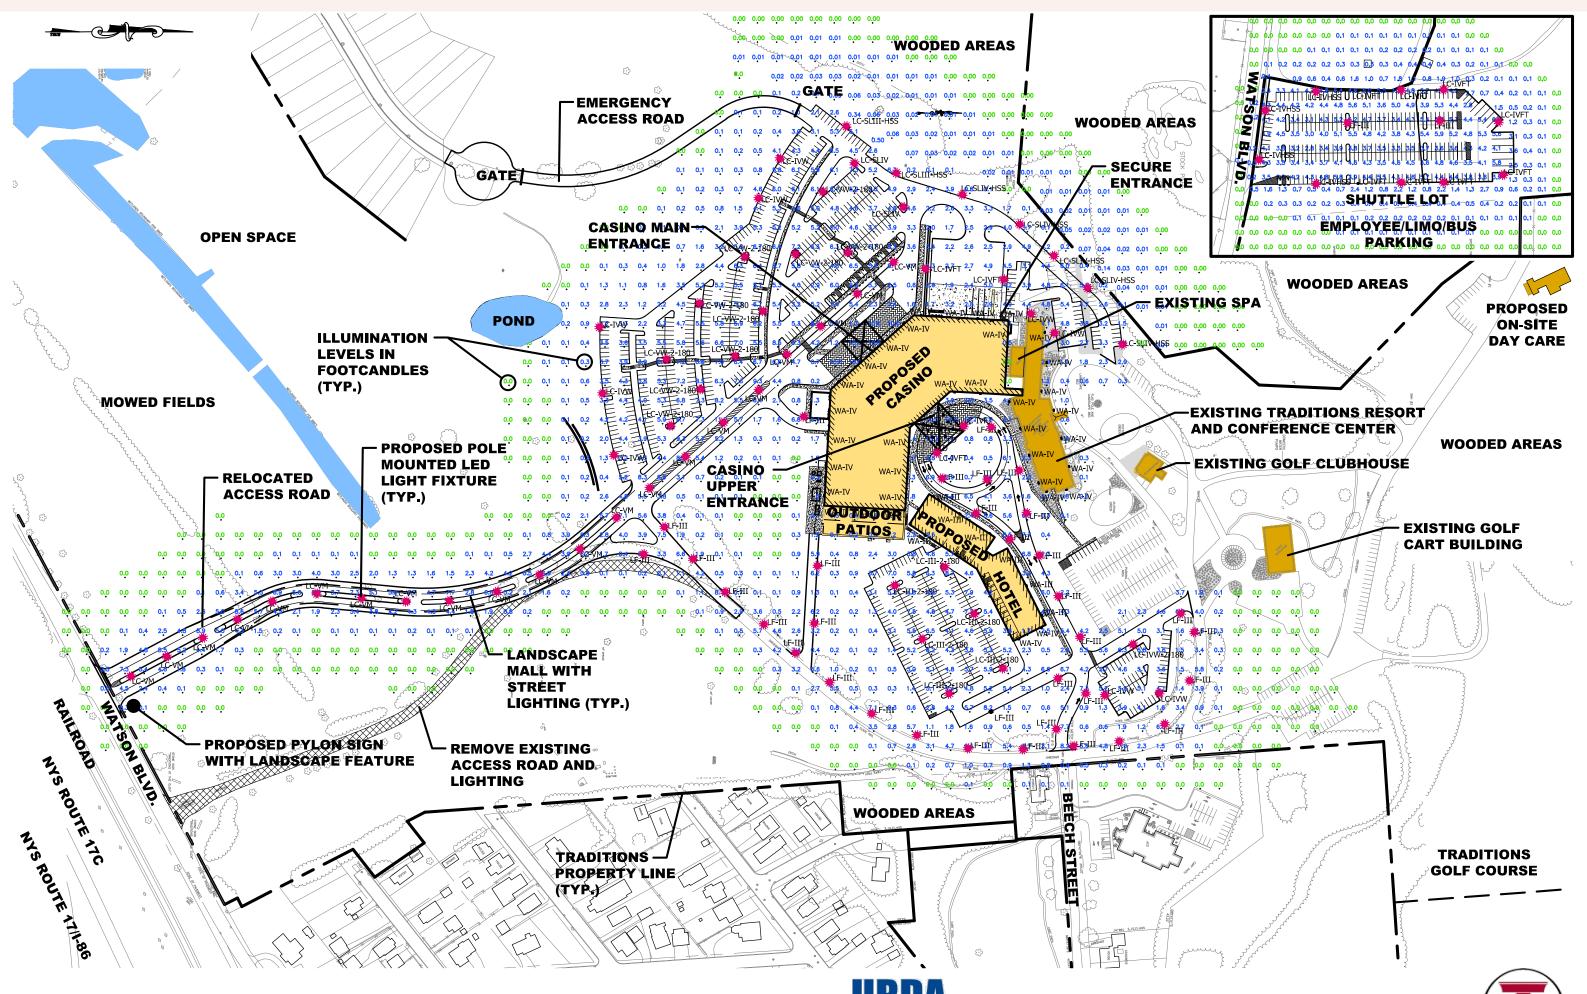


EXHIBIT: VIII.C.5.a.6.1 EXTERIOR LIGHTING PLAN

SCALE: 1" = 200' JUNE 30, 2014 rev: x



